


DIVERSION ROUTES

Church Hill
 Broad Street
 High Street
 A34
 Breedon
 Oxford Road
 Priors Court Road
 Newbury Road
 Hampstead Norreys Road
 B4009
 Isley Road
 VICE VERSA

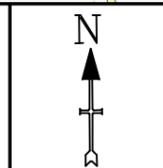

Cow Lane
Reading
RG20 7LL



Units 3, 4 & 5 River Moles Business Park
Mill Mead Road, Esher,
Surrey KT10 8BJ
Tel: 0800 6444 114
Web: www.tglgroup.co.uk
Email: tmdrawings@tglgroup.co.uk

1) TEMPORARY TRAFFIC MANAGEMENT TO BE SET OUT IN ACCORDANCE WITH CHAPTER 8 AND SAFE WORKING PRACTICES.
2) ALL BUS, PARKING AND LOADING BAYS SHOULD BE SUSPENDED WITH THE RELEVANT AUTHORITY PRIOR TO COMMENCEMENT OF WORK.
3) WORKS VEHICLES TO BE PARKED WITHIN WORKS AREA.

DATE DRAWN	26/03/25	Drawing No.
DRAWN BY	TGL DDC	3000-05.03 PG3 OF 4
CHECKED BY	TGL CJ	
SCALE	N.T.S.	


KEY

-  Traffic Barrier
-  No Parking Cones
-  Traffic Cones
-  Traffic Sign Direction
-  Ped Barriers
-  Works Area
-  Safety Zone


DIVERSION ROUTES



Church Hill
 Broad Street
 High Street
 A34
 Breedon
 Oxford Road
 Priors Court Road
 Newbury Road
 Hampstead Norreys Road
 B4009
 Isley Road
VICE VERSA

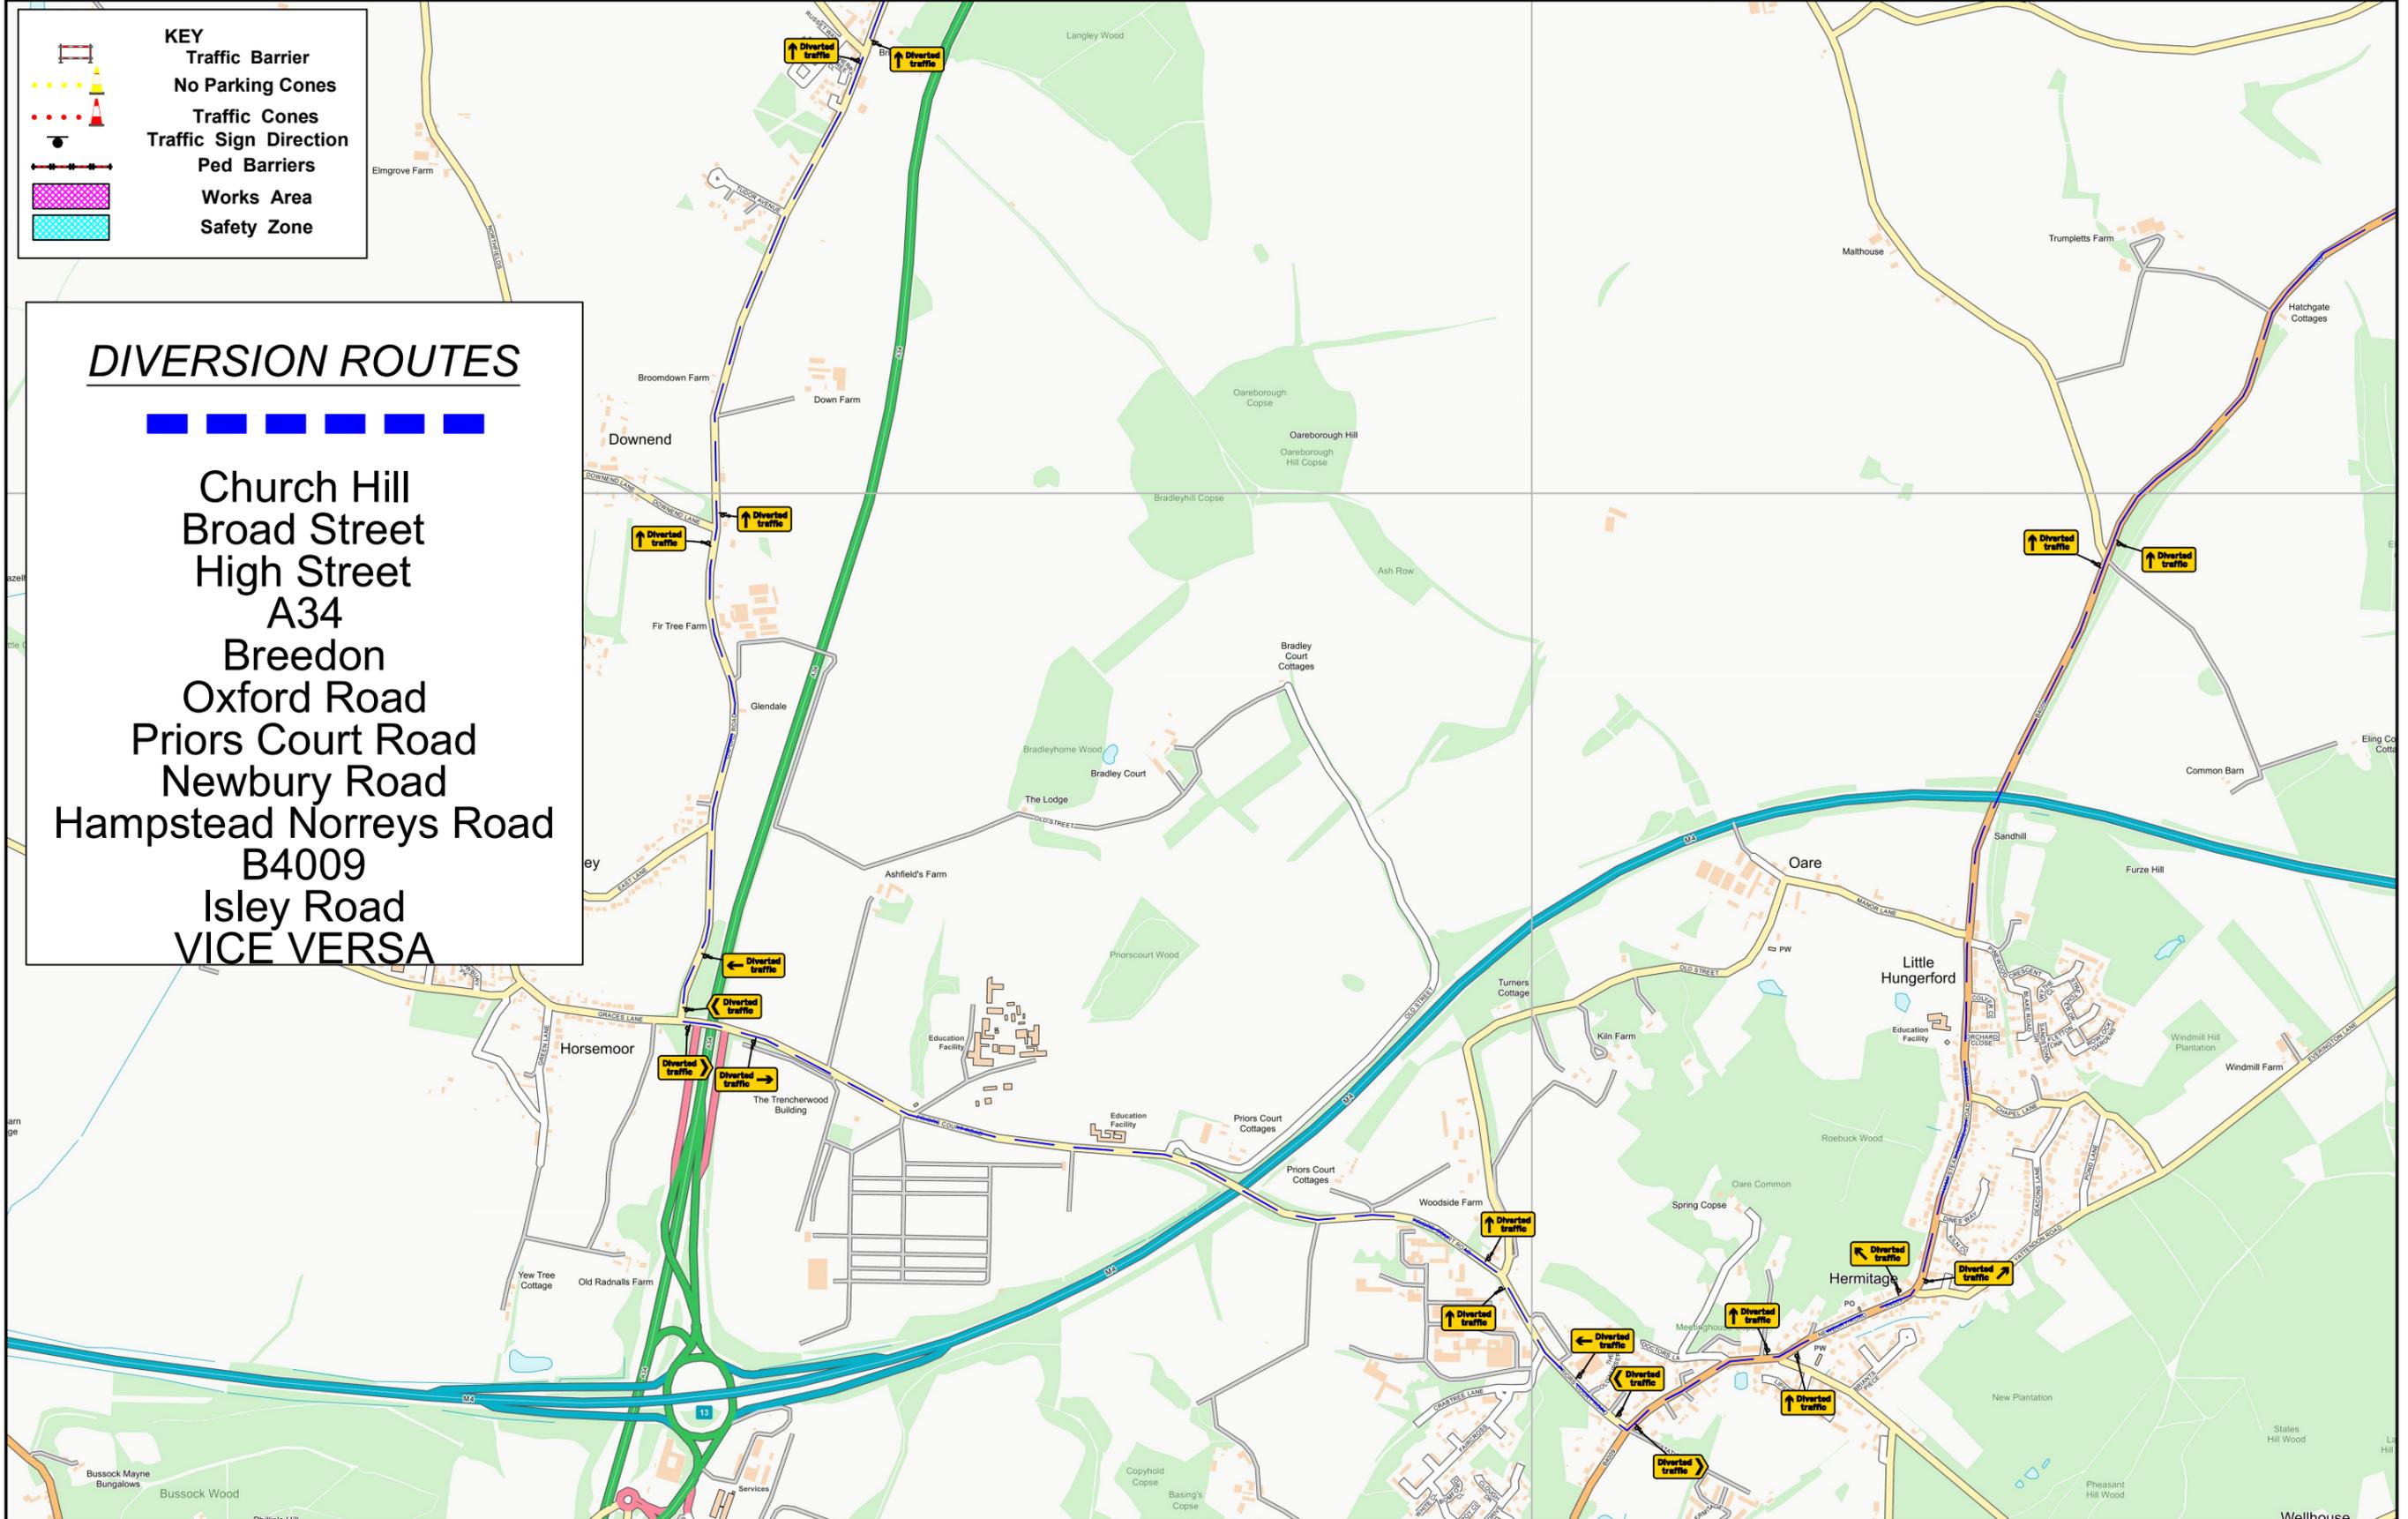

MORRISON
Utility Services

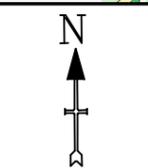

Cow Lane
 Reading
 RG20 7LL

TGL
 Traffic Guarding & Logistics
 TGL Group Ltd

Units 3, 4 & 5 River Moles Business Park
 Mill Mead Road, Esher,
 Surrey KT10 8BJ
 Tel: 0800 6444 114
 Web: www.tglgroup.co.uk
 Email: tmdrawings@tglgroup.co.uk

1) TEMPORARY TRAFFIC MANAGEMENT TO BE SET OUT IN ACCORDANCE WITH CHAPTER 8 AND SAFE WORKING PRACTICES.
 2) ALL BUS, PARKING AND LOADING BAYS SHOULD BE SUSPENDED WITH THE RELEVANT AUTHORITY PRIOR TO COMMENCEMENT OF WORK.
 3) WORKS VEHICLES TO BE PARKED WITHIN WORKS AREA.

DATE DRAWN	26/03/25	Drawing No.
DRAWN BY	TGL DDC	3000-05.04 PG4 OF 4
CHECKED BY	TGL CJ	
SCALE	N.T.S.	