

**KEY**

-  Traffic Barrier
-  No Parking Cones
-  Traffic Cones
-  Traffic Sign Direction
-  Ped Barriers
-  Works Area
-  Safety Zone



**DIVERSION ROUTES**



Church Hill  
 Broad Street  
 High Street  
 A34  
 Breedon  
 Oxford Road  
 Priors Court Road  
 Newbury Road  
 Hampstead Norreys Road  
 B4009  
 Isley Road  
**VICE VERSA**

**Cow Lane  
 access to residents only  
 all other traffic  
 follow diversion**

**Cow Lane  
 closed  
 No through route  
 follow diversion**

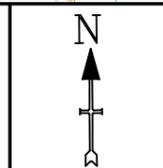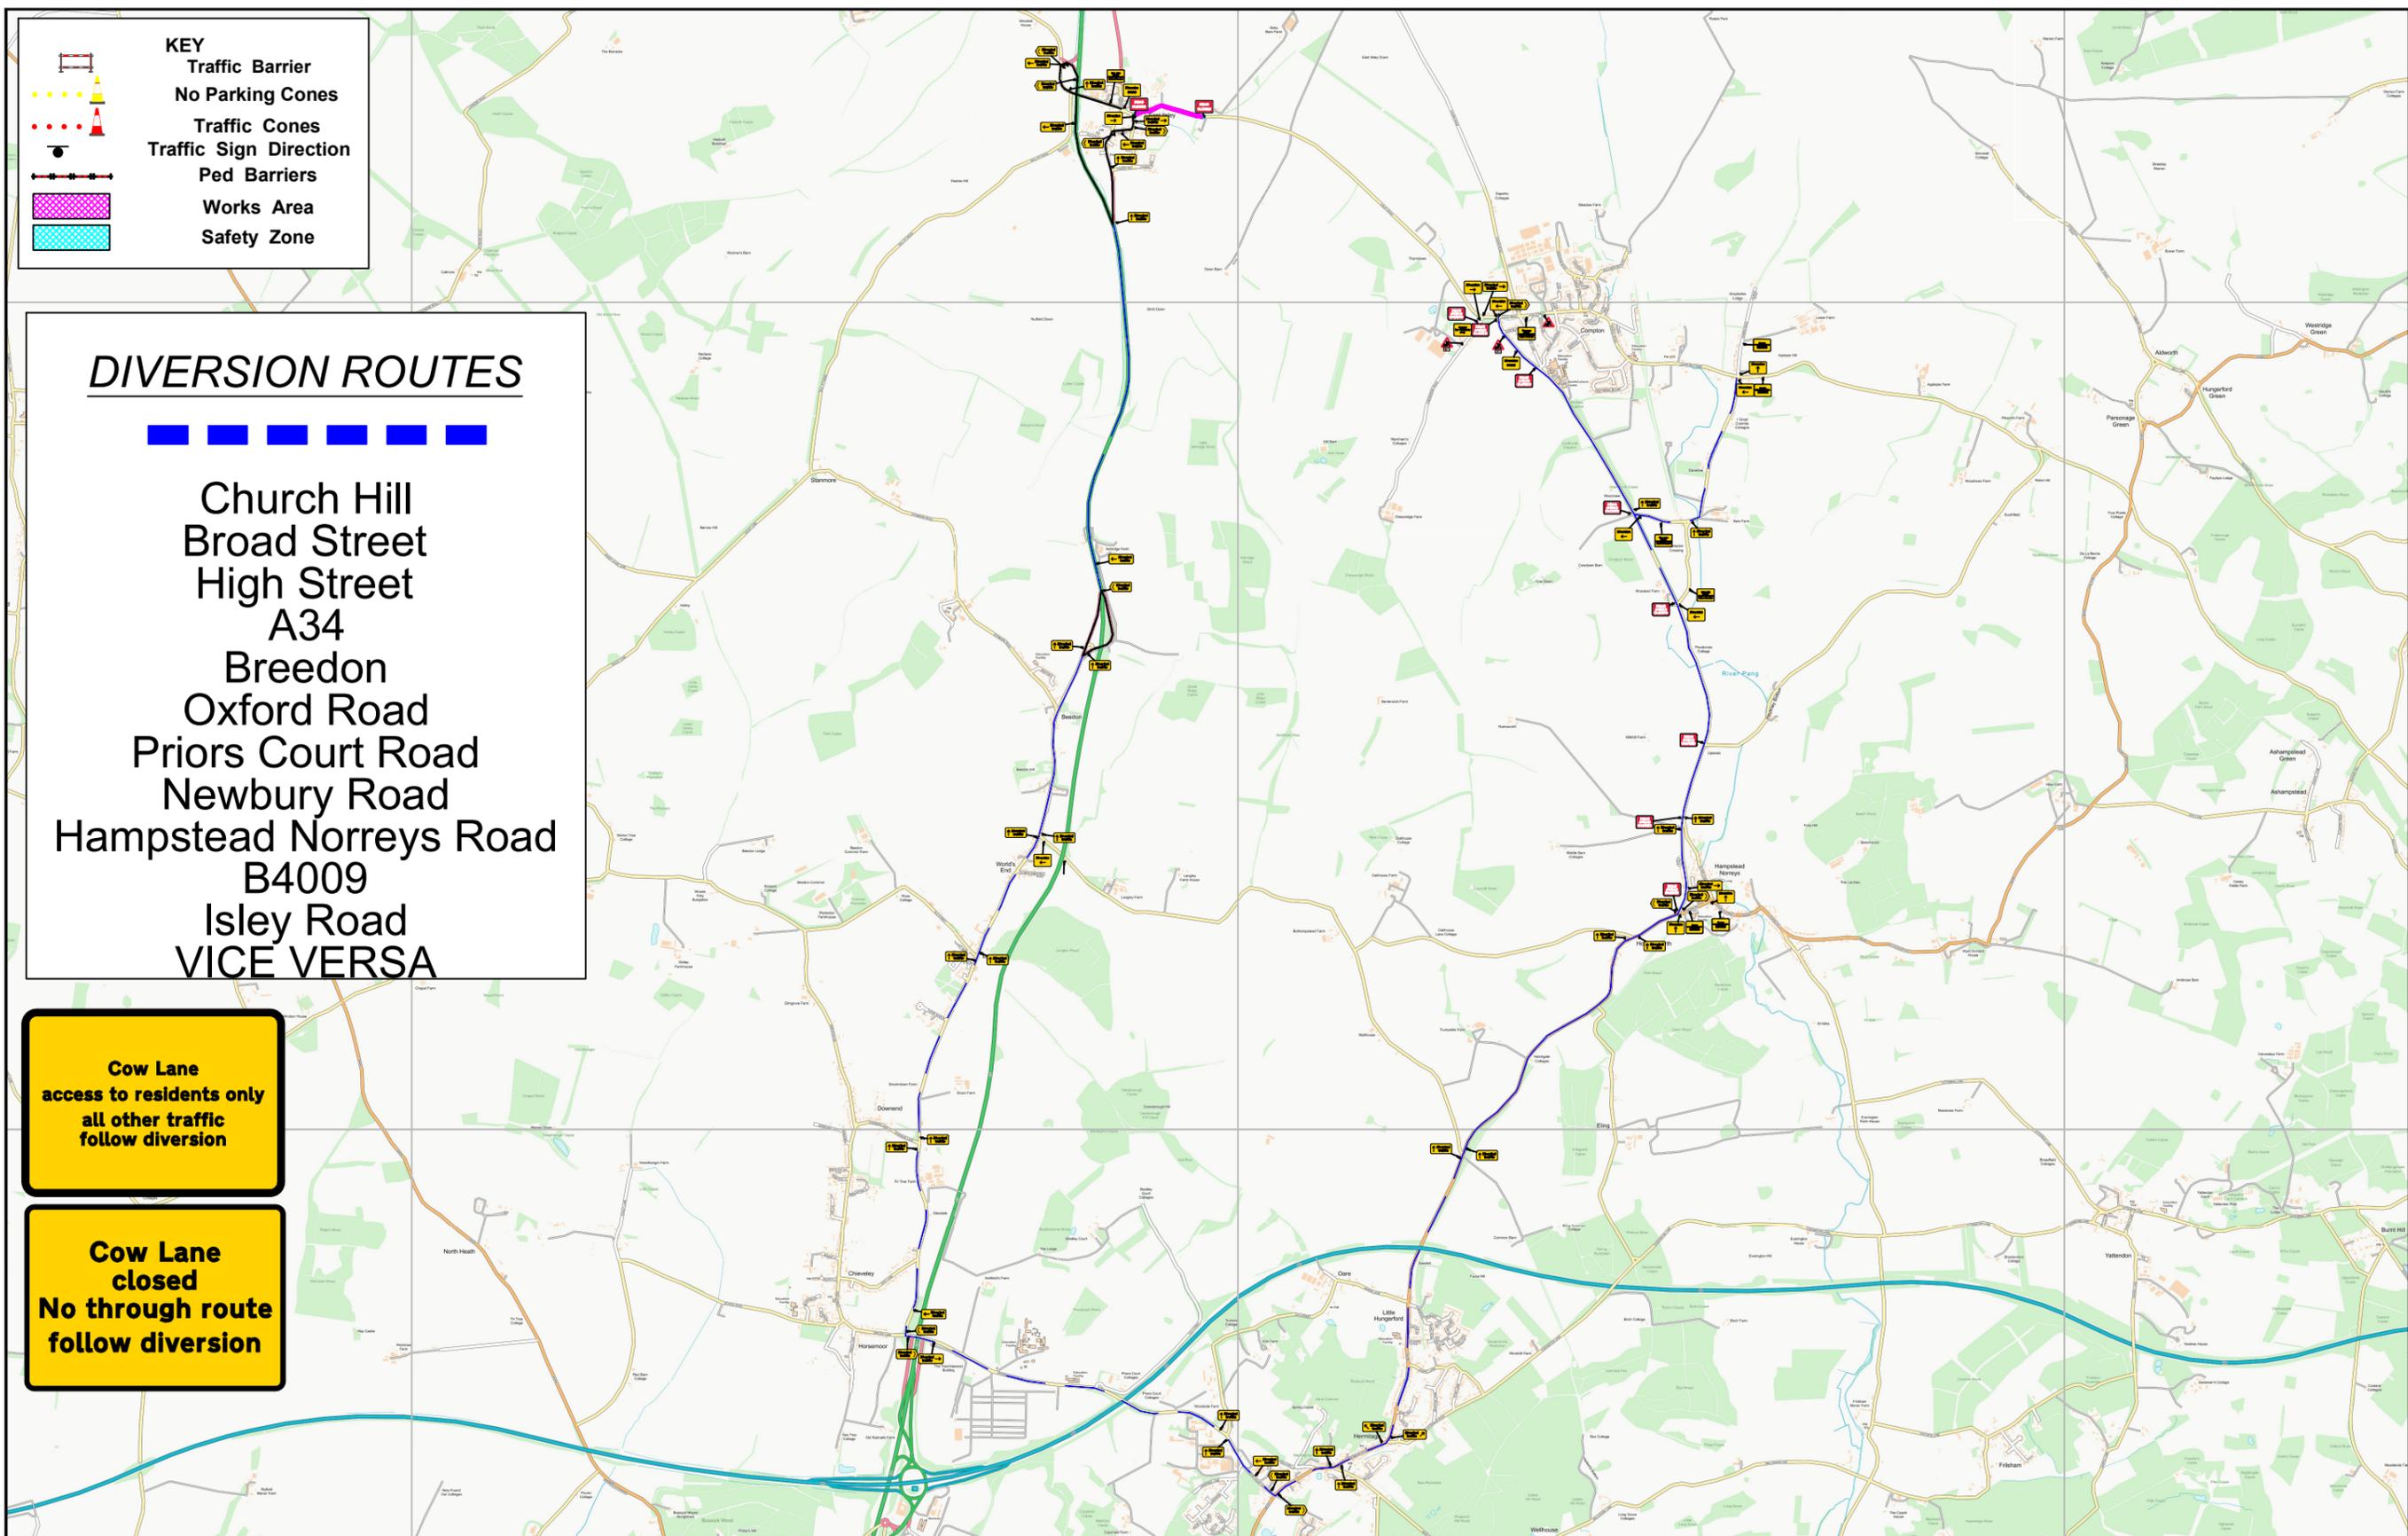

Cow Lane  
 Reading  
 RG20 7LL



Units 3, 4 & 5 River Moles Business Park  
 Mill Mead Road, Esher,  
 Surrey KT10 8BJ  
 Tel: 0800 6444 114  
 Web: www.tglgroup.co.uk  
 Email: tmdrawings@tglgroup.co.uk

1) TEMPORARY TRAFFIC MANAGEMENT TO BE SET OUT IN ACCORDANCE WITH CHAPTER 8 AND SAFE WORKING PRACTICES.  
 2) ALL BUS, PARKING AND LOADING BAYS SHOULD BE SUSPENDED WITH THE RELEVANT AUTHORITY PRIOR TO COMMENCEMENT OF WORK.  
 3) WORKS VEHICLES TO BE PARKED WITHIN WORKS AREA.

DATE DRAWN	26/03/25	Drawing No.
DRAWN BY	TGL DDC	3000-05.01 PG1 OF 4
CHECKED BY	TGL CJ	
SCALE	N.T.S.	